

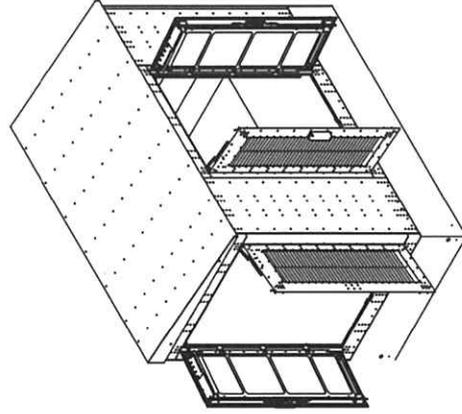


	REV.	DESCRIPTION	DATE	CHK.
	TITLE: LOCATION PLAN FOR PROPOSED HV PILLAR KAU LUNG HANG PKG			
DRAWN: Homer Yiu	Date: 16-01-2025	PROJECT NO.:	SS200519	
SCALE: 1:1000	SHEET(S) IN SET: 1/1	DRG. NO.	SS200519-001	

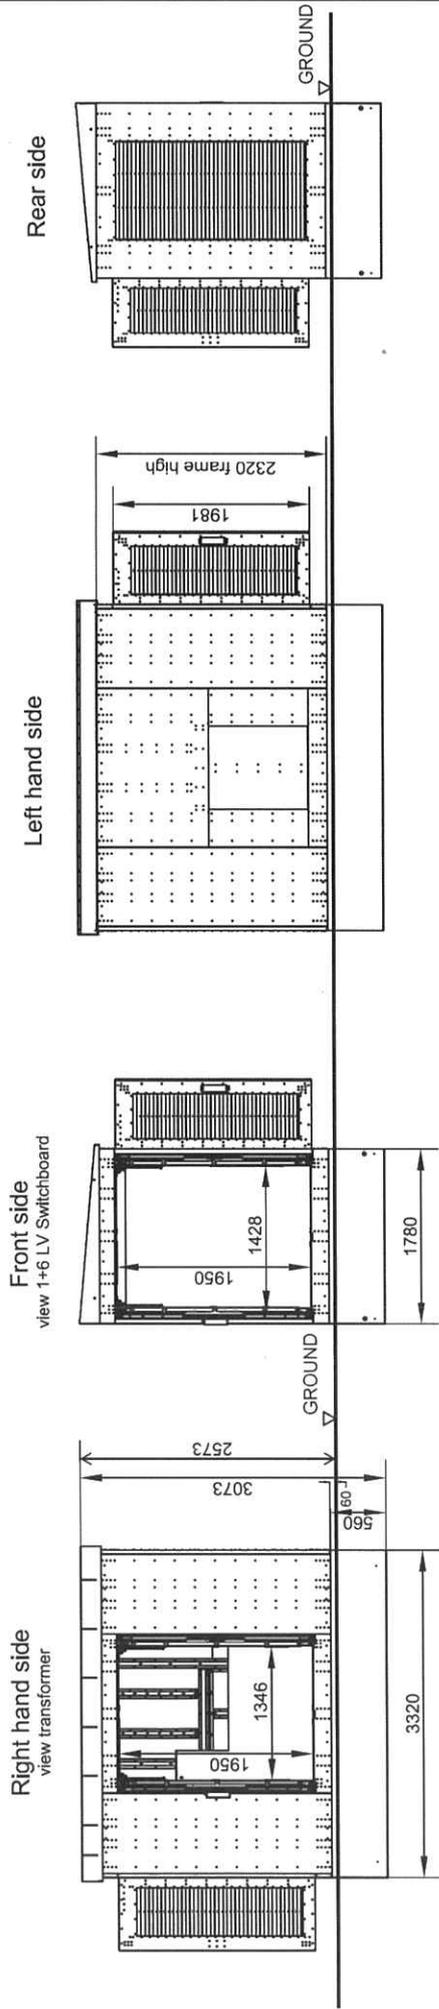


Top view (1 : 25)

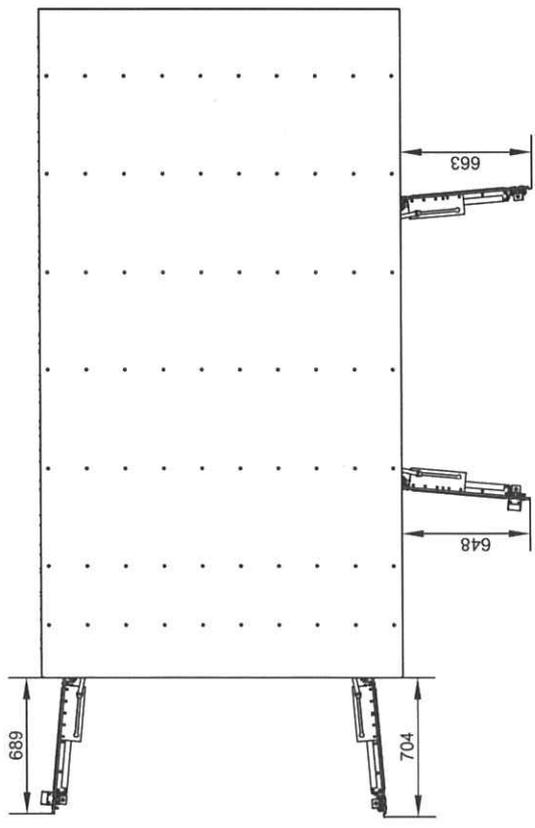


		REV.	DESCRIPTION	DATE	CHK.
		TITLE			
CONTRACTOR: SIEMENS LTD DRAWN: STEPHANE ISO CHECKED: RAYMOND WONG SCALE: NTS					
DATE: 01 - MAY - 2024 APPROVED: RAYMOND WONG SHEETS IN SET: 1 OF 1					
SIEMENS (BETONBAU GMBH & CO. KG) GRITEC HV EQUIPMENT PILLAR (NON-WALK-IN TYPE) LT COMPARTMENT - FLOOR PLAN OF HV PILLAR (DOORS OPENED)					
PROJECT NO. T.S.D.05.3.3.4.0 CONTRACT NO. 44800005 DRG. NO. T.S.H.5.1.7.2.0.3					
ASSET MANAGEMENT					
INFORMATION CLASS: PROPRIETARY					


Right hand side
view MV switchgear

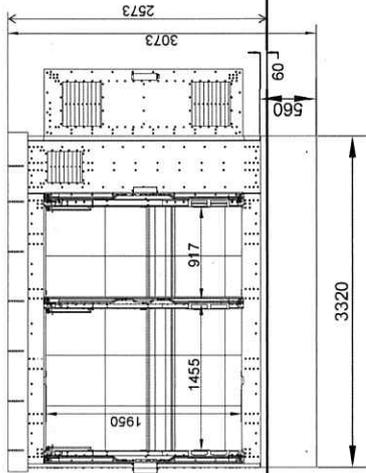

Rear side
view pressure relief channel

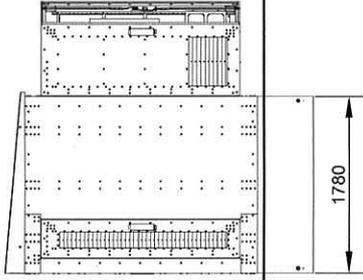


Left hand side



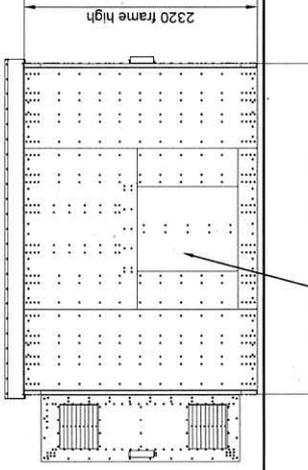


assembly hatch,
access between the
substations when placed
next to each other,
can be opened from the inside

Front side
view CRTU

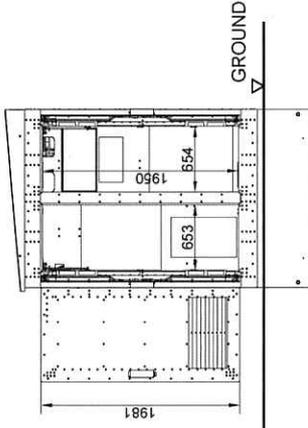

Top view (1 : 25)

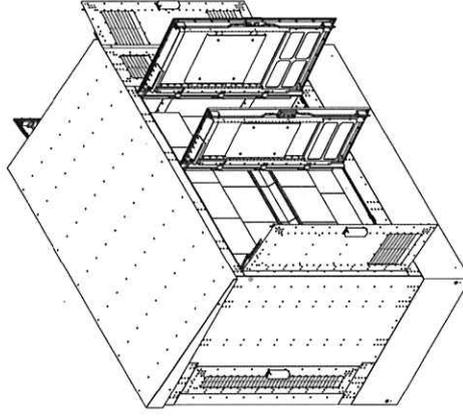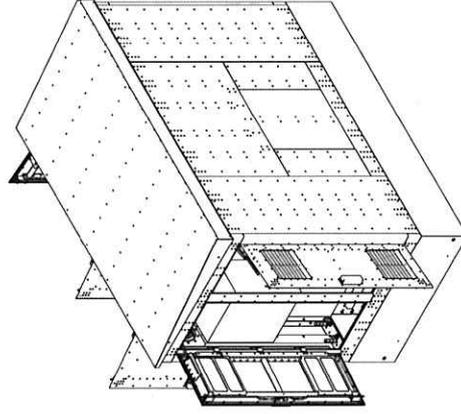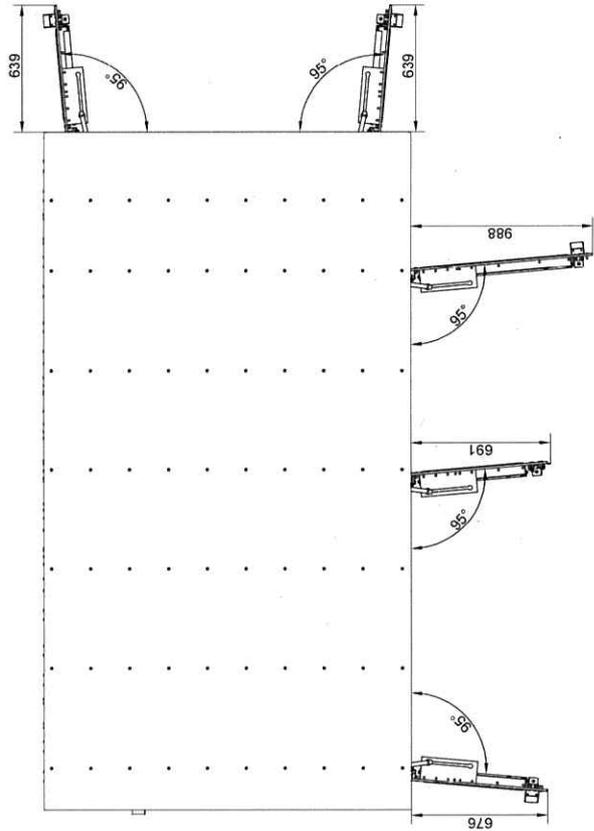

CONTRACTOR: SIEMENS LTD
DRAWN: STEPHANE ISH
CHECKED: RAYMOND WONG
SCALE: N/A

REV	DESCRIPTION	DATE	CHK
1	REVISION FOR HEAT SENSING SYSTEM	03 SEP 24	RM
TITLE			
SIEMENS (BETONBAU GMBH & CO. KG) GRITEC HV EQUIPMENT PILLAR (NON-WALK-IN TYPE)			
HV COMPARTMENT - FLOOR PLAN OF HV PILLAR (DOORS OPENED)			
PROJECT NO.	CONTRACT NO.	SHEET NO. (SEE 1 OF 1)	
0000000000	6000000000	T 1 2 3 100	
DRG. NO.	ASSET MANAGEMENT		