



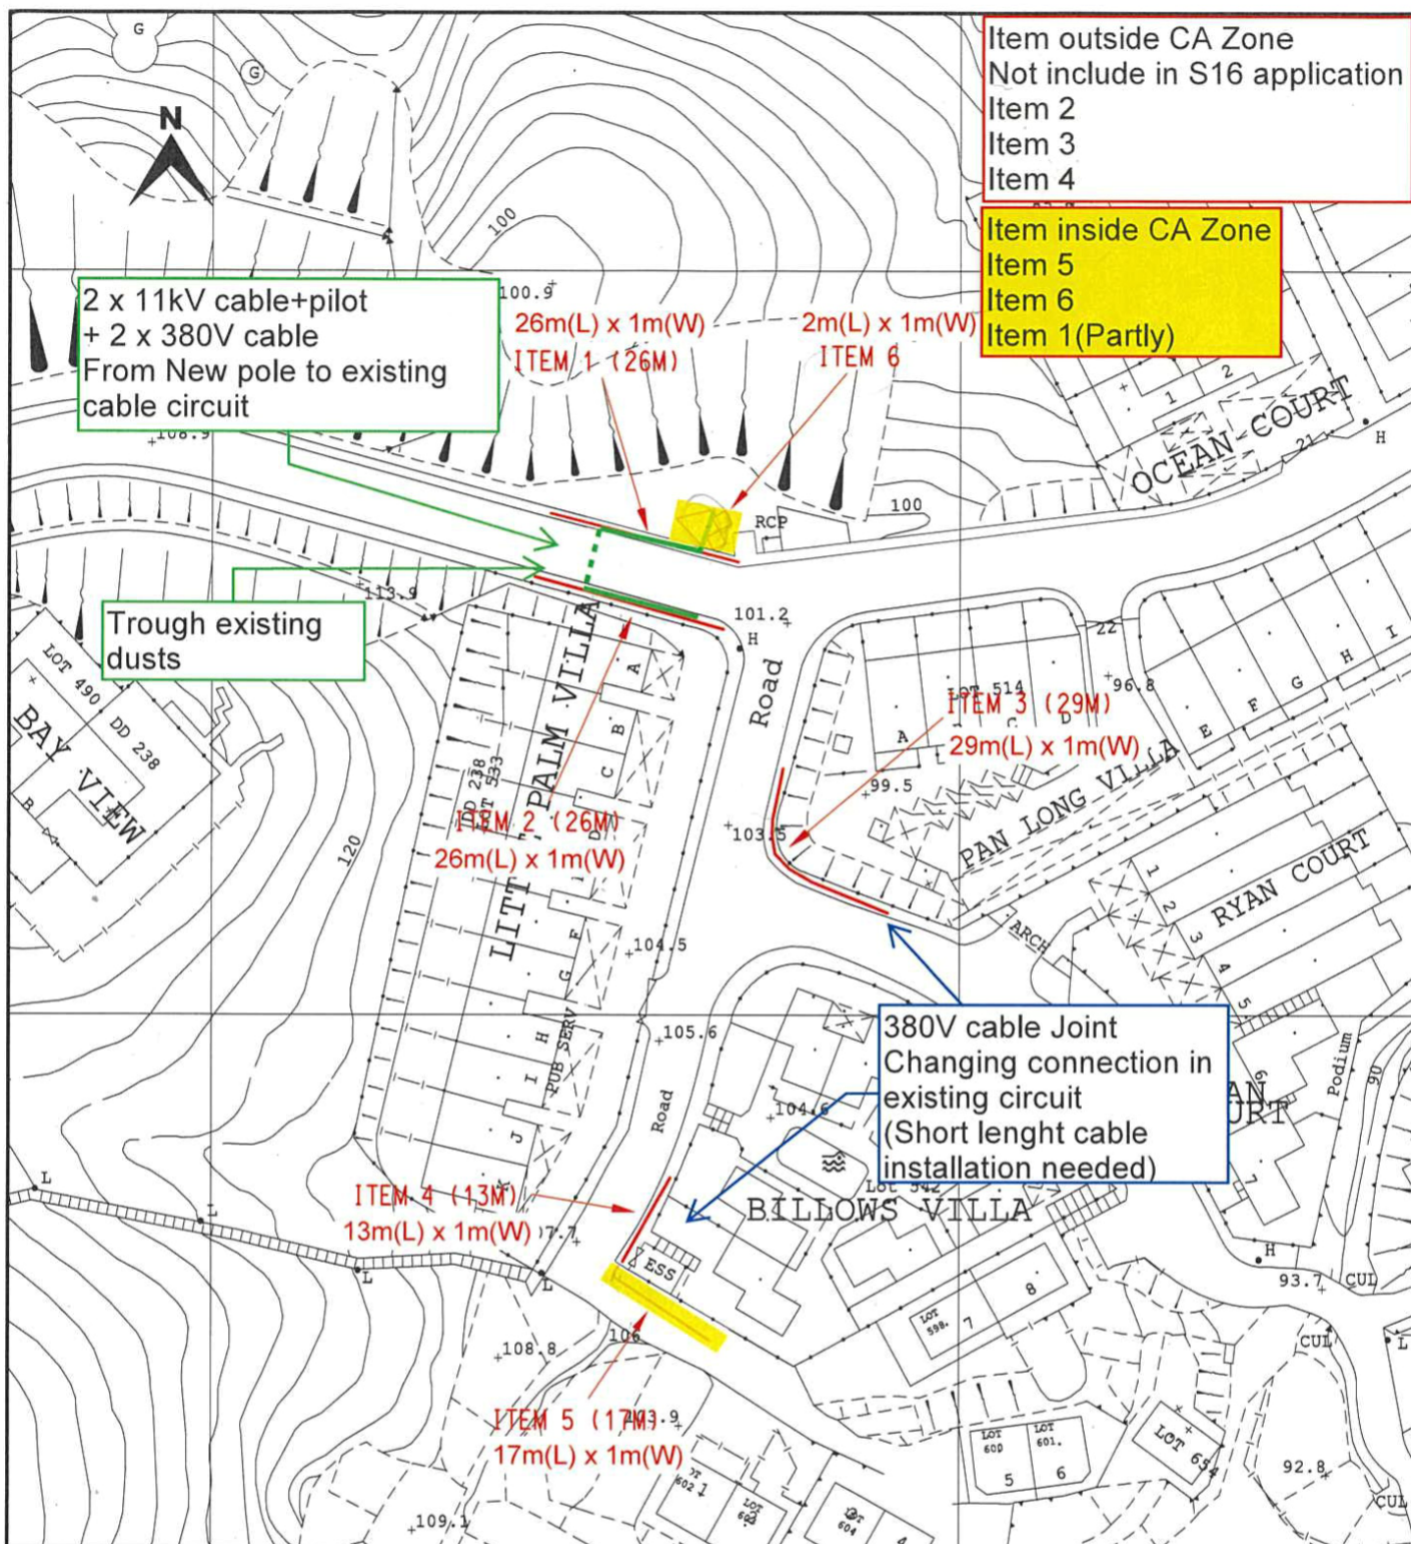

Map data reproduced with permission of the Director of Lands. (C) Hong Kong

(資料來源：申請人於 30.08.2021 呈交的資料)
(Source : Applicant's Submission of 30.08.2021)

參考編號 REFERENCE No. A/SK-CWBN/67	繪圖 DRAWING A-1
---------------------------------------	----------------------

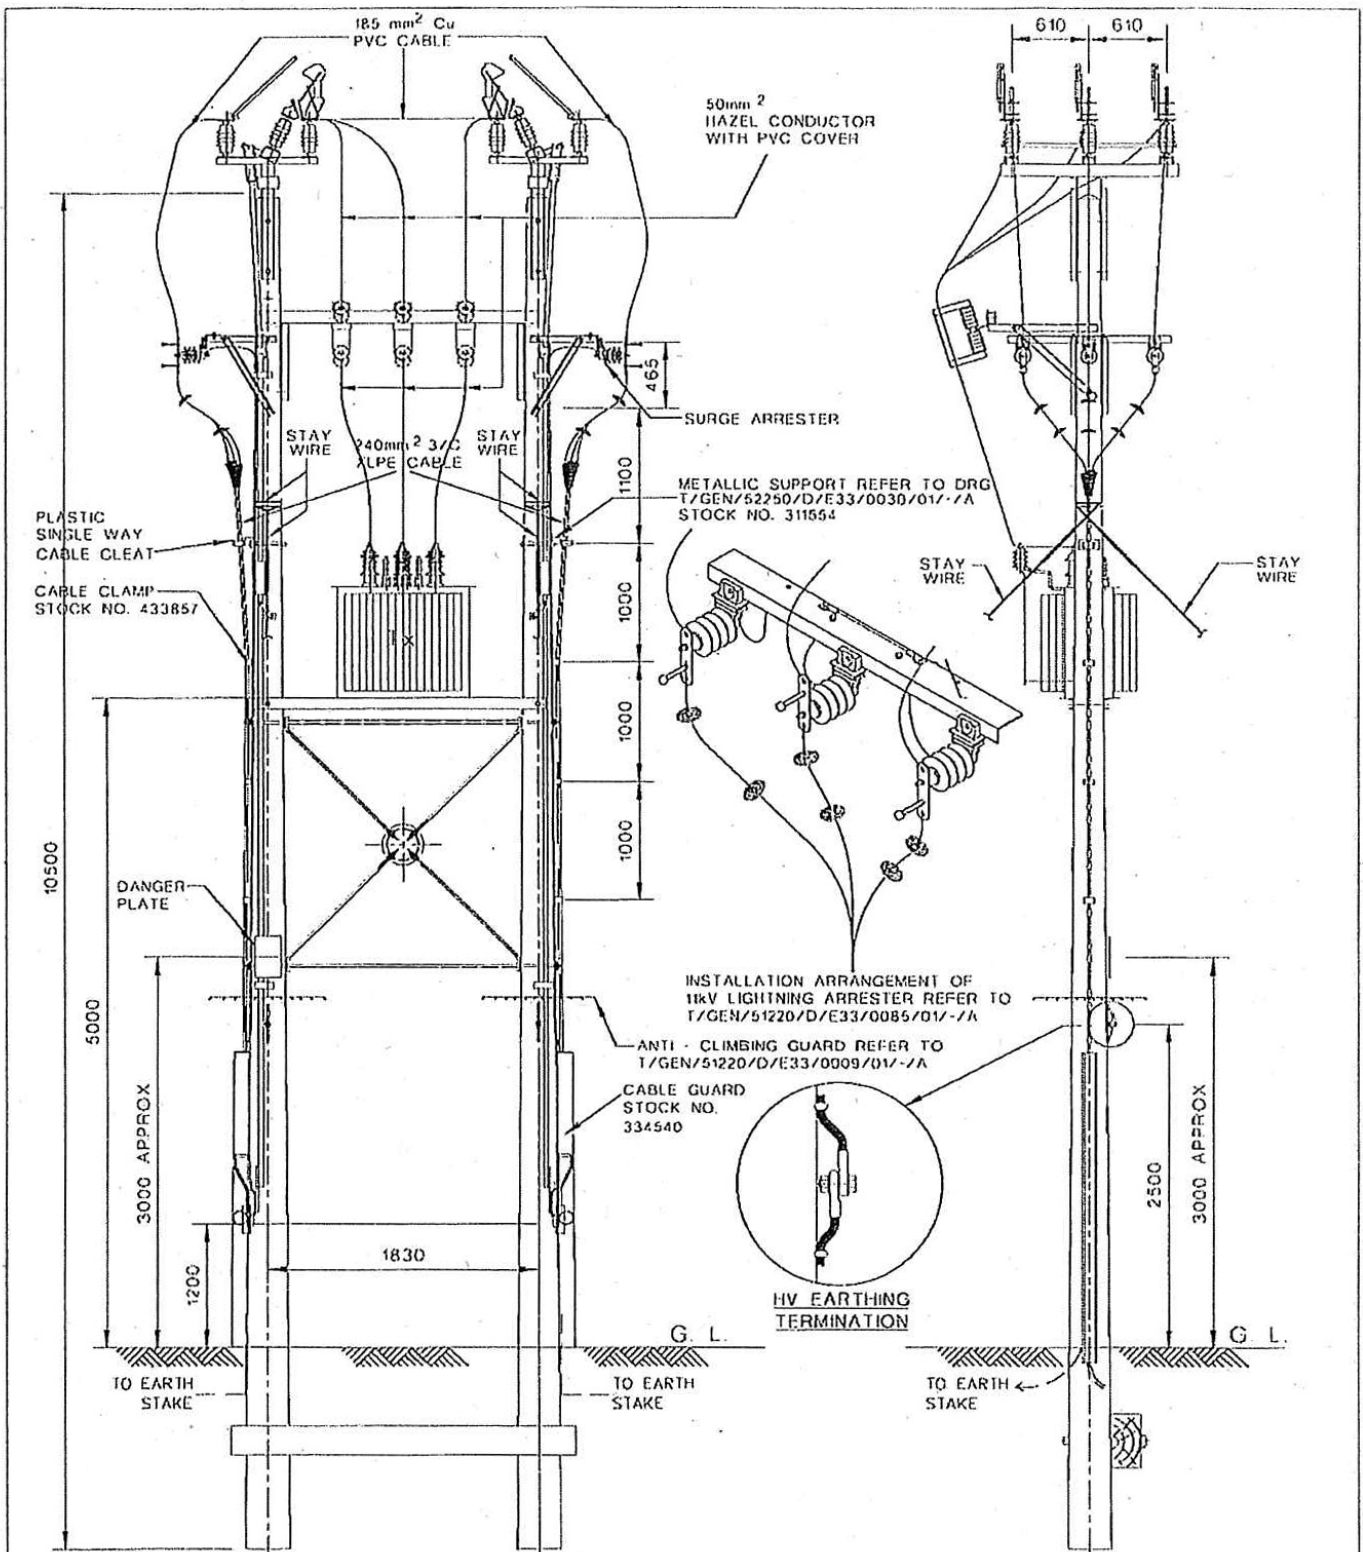

NOTES:

1. THIS CONFIGURATION WAS A REPIA OF EXISTING INSTALLATIONS PRIOR TO YEAR 2000 AS REQUESTED BY QC-OHL
2. PLEASE REFER TO THE MEMO REF : M/06510/02-06/JC/JC DATED 24/6/02 AND STRUCTURAL ENGINEER'S REPORT (MEINHARDT) ON 21/5/2002.
3. FOR OPERATION ON EQUIPMENT PLEASE REFER TO RELEVANT DSOM CHAPTER.
4. FOR DETAILS OF INDIVIDUAL CONSTRUCTION PLEASE REFER TO RELEVANT STANDARD DRAWING.
5. ALL DIMENSIONS ARE IN mm.

CLP 中電

DRAWN: S.C.T.O DATE: 5-5-2000
 CHECKED: C.Y.IP / F.CHOY APPROVED: K.S.YEUNG
 SCALE N.T.S. SHEET(S) IN SET 1

ASSET MANAGEMENT


REVS.	26.2.02	21.3.03									
	A	B	C	D	E	F	G	H	J	K	L
INITIAL	H.C.C.	H.C.C.									
TITLE											
TYPICAL LAYOUT FOR DOUBLE POLES INSTALLATION WITH TWO ISOLATORS AND FUSED TRANSFORMER FED BY CABLES											
PROJECT NO.						CONTRACT NO.					
DRG. NO. T GEN 51220 D E33 0084 01 B A											

ALL RIGHTS RESERVED AND REPRODUCTION IN ANY FORM MUST BE APPROVED BY CLP POWER

(資料來源：申請人於 30.08.2021 呈交的資料)
 (Source : Applicant's Submission of 30.08.2021)

參考編號
 REFERENCE No.
A/SK-CWBN/67


繪圖
 DRAWING
A-2

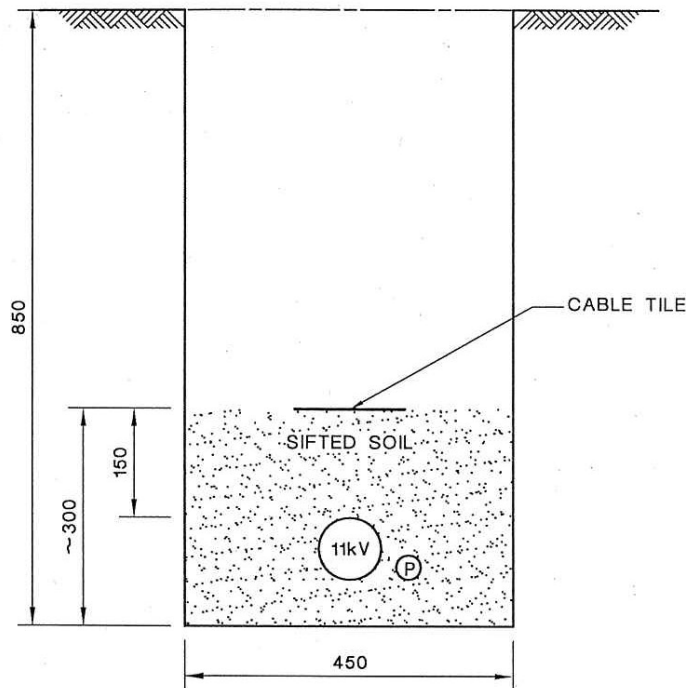

NOTES:

1. ALL SOIL BACKFILLING BENEATH CABLE TILES TO BE SIFTED THROUGH 12mm WIRE MESH.
2. ALL DIMENSIONS ARE IN mm

EXISTING ARRANGEMENT OF 11kV CABLE TRENCH

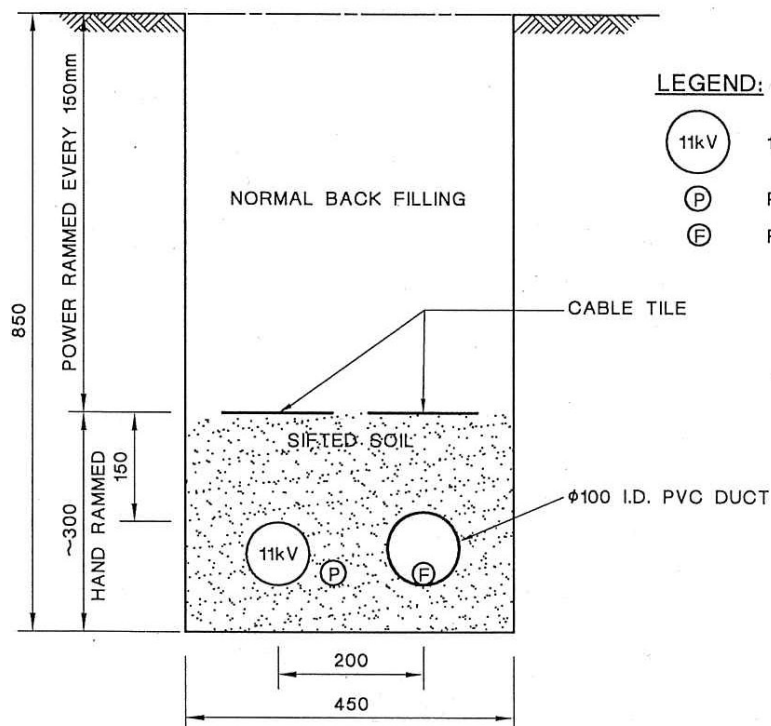

LEGEND:

- 11kV 11kV 3/C XLPE POWER CABLE
- (P) PILOT CABLE
- (F) FIBRE OPTIC CABLE

11kV CABLE TRENCH WITH FIBRE OPTIC CABLE IN PVC DUCT

D	GENERAL REVISION	C	NOTE ADDED	A	NO AMENDMENT AFTER REVIEW
---	------------------	---	------------	---	---------------------------

CLP 中電

DRAWN: K. F. CHEUNG DATE: 11-4-2000

CHECKED: C. Y. IP APPROVED: W. B. LEE

SCALE: SHEET(S) IN SET: 1

REVS. 15.8.03 4.4.07 18.6.07 28.6.11

INITIAL C.F.YAM Y.K.MAN W.B.LEE Y.K.MAN

TITLE: TYPICAL 11kV CABLE TRENCH WITH PILOT AND FIBRE OPTIC CABLES - TYPE II


PROJECT NO. CONTRACT NO.

ASSET MANAGEMENT DRG. NO. T G E N 1 0 5 2 0 D E 3 3 0 0 0 6 0 1 D A


ALL RIGHTS RESERVED AND REPRODUCTION IN ANY FORM MUST BE APPROVED BY CLP POWER

(資料來源：申請人於 30.08.2021 呈交的資料)
(Source : Applicant's Submission of 30.08.2021)

參考編號 REFERENCE No. A/SK-CWBN/67	繪圖 DRAWING A-3
---------------------------------------	----------------------

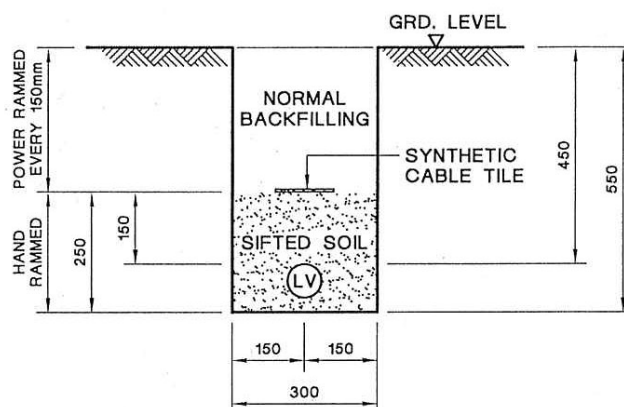

TYPICAL CABLE TRENCH FOR SINGLE LV CABLE

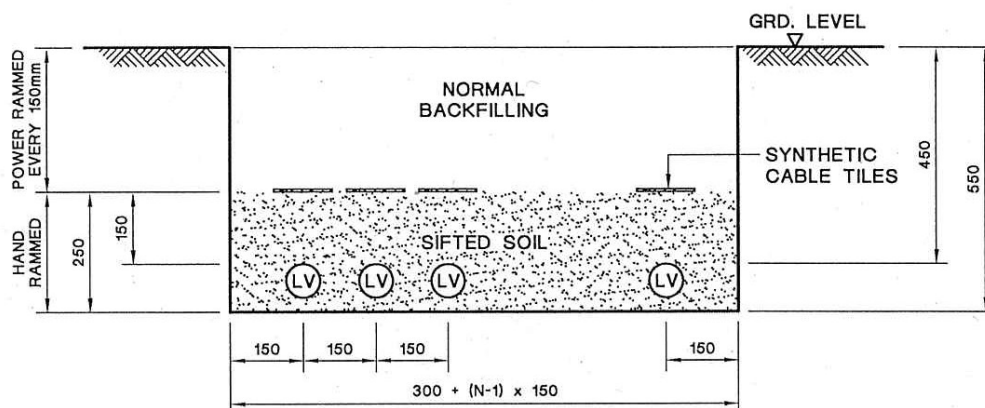

TYPICAL CABLE TRENCH FOR MULTIPLE LV CABLES

LEGEND :

- (LV) LV CABLE
N NUMBER OF CABLE CIRCUITS

NOTES:

1. ALL SOIL BACKFILLING BENEATH CABLE TILES SHALL BE SIFTED THROUGH 12mm WIRE MESH.
2. ALL DIMENSIONS ARE IN mm.

C GENERAL REVISION		B GENERAL REVISION		A SYNTHETIC CABLE TILE SPECIFIED									
		REVS.	16-2-04	18-6-07	28-6-07								
		INITIAL	C.Y.IP	W.B.LEE	Y.K.MAN	D	E	F	G	H	J	K	L
DRAWN: S.C.T.		DATE: 15 Aug., 2003		TITLE : TYPICAL LV CABLE TRENCH									
CHECKED: K. K. LEUNG		APPROVED: W. B. LEE											
SCALE:		SHEET(S) IN SET: 1		PROJECT NO.					CONTRACT NO.				
ASSET MANAGEMENT				DRG. NO. T GEN 25500 DE 33 0002 01 C A									

ALL RIGHTS RESERVED AND REPRODUCTION IN ANY FORM MUST BE APPROVED BY CLP POWER


(資料來源：申請人於 30.08.2021 呈交的資料)
(Source : Applicant's Submission of 30.08.2021)

參考編號 REFERENCE No. A/SK-CWBN/67	繪圖 DRAWING A-4
---------------------------------------	----------------------



要覽圖 KEY PLAN

SCALE 1 : 50 000 比例尺

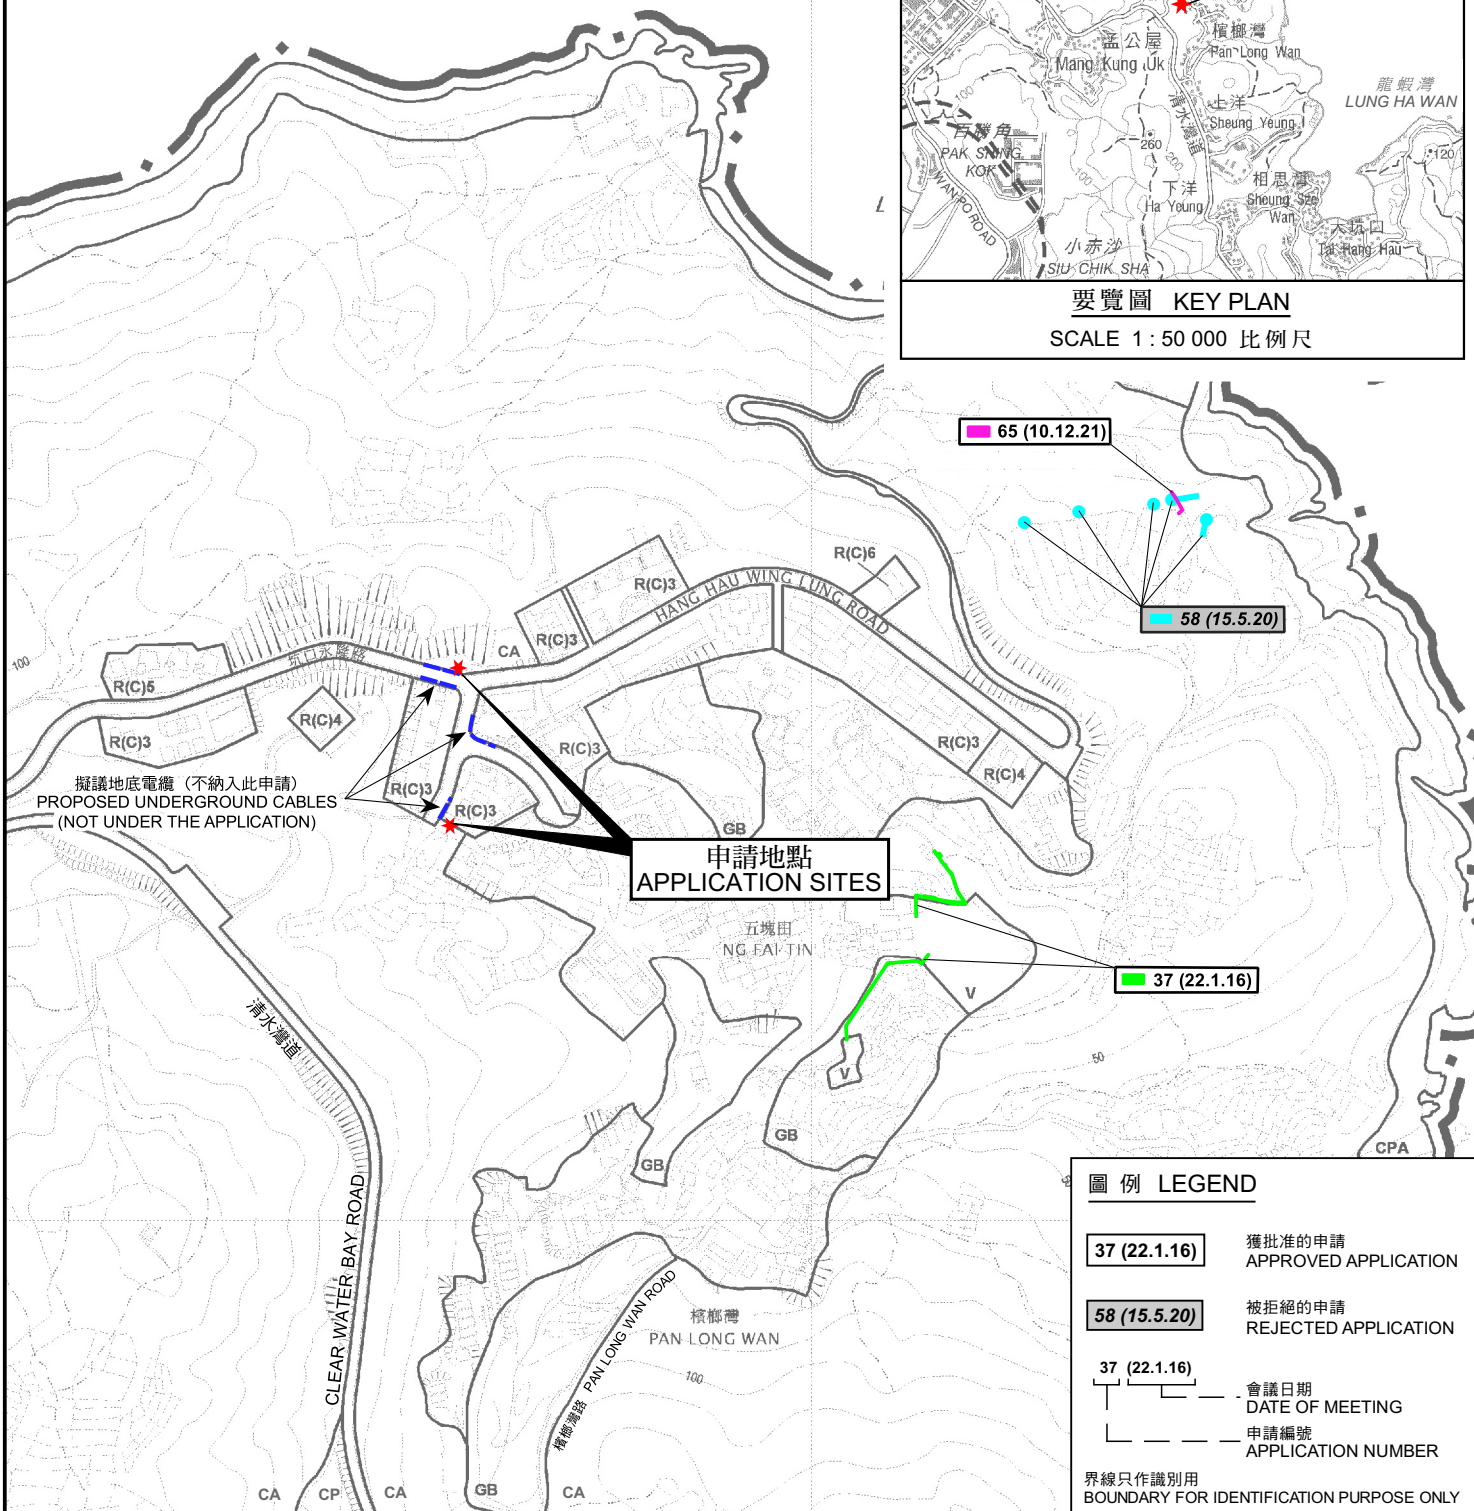

圖例 LEGEND

- 37 (22.1.16) 獲批准的申請 APPROVED APPLICATION
- 58 (15.5.20) 被拒絕的申請 REJECTED APPLICATION
- 37 (22.1.16) 會議日期 DATE OF MEETING
- 申請編號 APPLICATION NUMBER

界線只作識別用
BOUNDARY FOR IDENTIFICATION PURPOSE ONLY

位置圖 LOCATION PLAN

擬議公用事業設施裝置（電線杆連變壓器和地底電纜）和挖土工程
西貢清水灣坑口永隆路丈量約份第 2 3 8 約的政府土地
PROPOSED PUBLIC UTILITY INSTALLATION
(POLE WITH TRANSFORMER AND UNDERGROUND CABLES)
AND EXCAVATION OF LAND
GOVERNMENT LAND IN D.D. 238, HANG HAU WING LUNG ROAD,
CLEAR WATER BAY, SAI KUNG
SCALE 1 : 5 000 比例尺

米 100 0 100 200 米
METRES


規劃署
PLANNING
DEPARTMENT



參考編號
REFERENCE No.
A/SK-CWBN/67

圖 PLAN
A-1

本摘要圖於2022年4月26日擬備，
所根據的資料為於2013年12月3日核准的
分區計劃大綱圖編號S/SK-CWBN/6
EXTRACT PLAN PREPARED ON 26.4.2022
BASED ON OUTLINE ZONING PLAN No.
S/SK-CWBN/6 APPROVED ON 3.12.2013

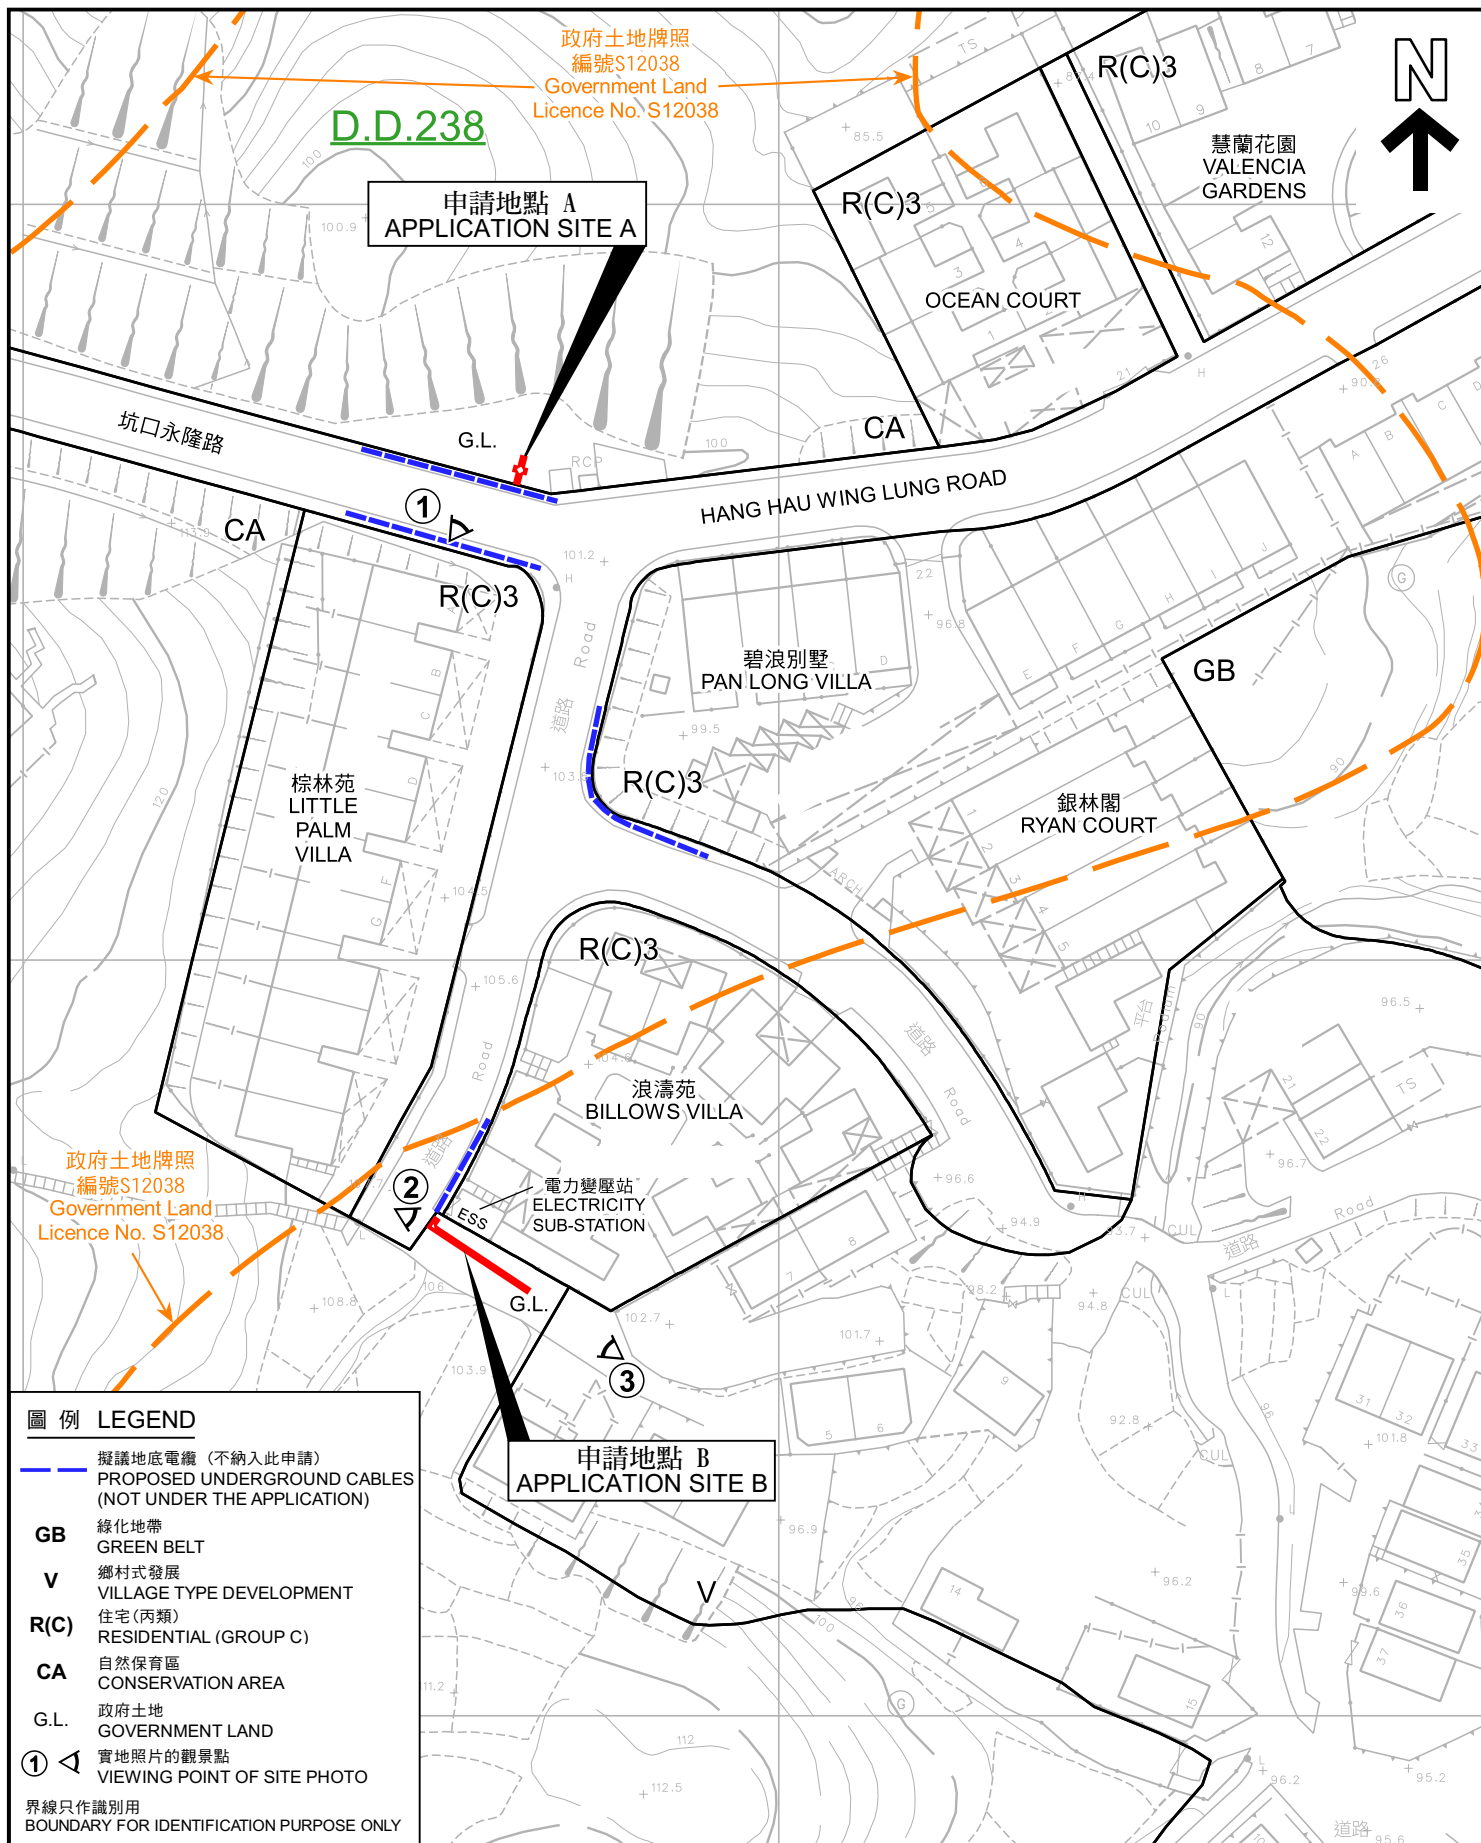

本摘要圖於2022年4月27日擬備， 所根據的資料為測量圖編號 12-NW-17A、B、C 和 D EXTRACT PLAN PREPARED ON 27.4.2022 BASED ON SURVEY SHEETS No. 12-NW-17A, B, C & D	平面圖 SITE PLAN 擬議公用事業設施裝置 (電線杆連變壓器和地底電纜) 和挖土工程 西貢清水灣坑口永隆路丈量約份第 2 3 8 約的政府土地 PROPOSED PUBLIC UTILITY INSTALLATION (POLE WITH TRANSFORMER AND UNDERGROUND CABLES) AND EXCAVATION OF LAND GOVERNMENT LAND IN D.D. 238, HANG HAU WING LUNG ROAD, CLEAR WATER BAY, SAI KUNG SCALE 1 : 1 000 比例尺 米 20 0 20 40 米 METRES	規劃署 PLANNING DEPARTMENT 參考編號 REFERENCE No. A/SK-CWBN/67 圖 PLAN A-2
--	--	---



圖例 LEGEND

擬議地底電纜 (不納入此申請)
PROPOSED UNDERGROUND CABLES
(NOT UNDER THE APPLICATION)

界線只作識別用
BOUNDARY FOR IDENTIFICATION PURPOSE ONLY

航攝照片 AERIAL PHOTO

本摘要圖於2022年4月19日擬備，所根據的資料為地政總署於2020年12月7日拍得的航攝照片編號 E117708C
EXTRACT PLAN PREPARED ON 19.4.2022
BASED ON AERIAL PHOTO No.
E117708C TAKEN ON 7.12.2020
BY LANDS DEPARTMENT

擬議公用事業設施裝置 (電線杆連變壓器和地底電纜) 和挖土工程
西貢清水灣坑口永隆路丈量約份第 2 3 8 約的政府土地
PROPOSED PUBLIC UTILITY INSTALLATION
(POLE WITH TRANSFORMER AND UNDERGROUND CABLES)
AND EXCAVATION OF LAND
GOVERNMENT LAND IN D.D. 238, HANG HAU WING LUNG ROAD,

規劃署
PLANNING
DEPARTMENT



參考編號
REFERENCE No.
A/SK-CWBN/67

圖 PLAN
A-3

1



2



3



界線只作識別用 BOUNDARY FOR IDENTIFICATION PURPOSE ONLY

實地照片 SITE PHOTO

擬議公用事業設施裝置（電線杆連變壓器和地底電纜）和 挖土工程
西貢清水灣坑口永隆路丈量約份第 2 3 8 約的政府土地
PROPOSED PUBLIC UTILITY INSTALLATION
(POLE WITH TRANSFORMER AND UNDERGROUND CABLES)
AND EXCAVATION OF LAND
GOVERNMENT LAND IN D.D. 238, HANG HAU WING LUNG ROAD,
CLEAR WATER BAY, SAI KUNG

規劃署
PLANNING
DEPARTMENT



參考編號
REFERENCE No.
A/SK-CWBN/67

圖 PLAN
A-4

本圖於2022年4月27日擬備，所根據的
資料為攝於2022年4月25日的實地照片
PLAN PREPARED ON 27.4.2022
BASED ON SITE PHOTOS
TAKEN ON 25.4.2022